

TAG #	SIZE	DESCRIPTION	ELEVATION
A1-4	3" 600# RFWN	INLET	2'-2 1/4" FTOS
B	4" 600# RFWN	GROUP OUTLET	0'-6 1/2" FTOS
C	2" 3000# NPT UNION	V-100 MANUAL DRAIN	1'-4 1/8" FTOS
D	2" 150# RFWN	PSV-100 VENT	7'-7 1/4" FTOS
E	1" 3000# NPT UNION	PROPANE SUPPLY	2'-1 1/4" FTOS
F	1" NPT	PSV-200 VENT	3'-8 1/2" FTOS
G	1" 3000# NPT UNION	WATER PROVER PORT - OUT	2'-2 1/2" FTOS
H	1" 3000# NPT UNION	WATER PROVER PORT - IN	2'-2 1/4" FTOS
J	1" 3000# NPT UNION	FUEL GAS	4'-3" FTOS
K	1" 3000# NPT UNION	INSTRUMENT AIR SUPPLY	3'-8 3/8" FTOS
L	1" 3000# NPT UNION	FUEL GAS SCRUBBER DRAIN	0'-6 1/4" FTOS

- NOTES:
- ELEVATION MEASUREMENTS ARE FROM TOP OF SKID (FTOS).
- TO GET A BOTTOM OF SKID MEASUREMENT (FBOS)
ADD 8 3/8" TO THE ELEVATIONS LISTED
 - PROJECTION MEASUREMENTS ARE FROM BUILDING EDGE. (FBE)

SHIPPING DIMENSIONS:
WIDTH: 12'-6"
LENGTH: 23'-7"
HEIGHT: 12'-0"
PACKAGE WEIGHT: 15,500lbs (approximate)



REV	ISSUED FOR CONSTRUCTION	REVISION	BY	APPR	d/m/y
0	ISSUED FOR CONSTRUCTION		BYC	APPR	18/09/14

Evolution
PRODUCTION EQUIPMENT

info@evolutionequipment.com
www.evolutionequipment.com

DATE 25/11/11	DESIGNED BY M.E.W.	DRAWN BY M.E.W.	CHECKED BY M.E.W.
CLIENT LONGRUN EXPLORATION LTD			
TITLE LAYOUT - PLAN VIEW			
JOB # EV-14211			
SHEET NO. OF 6			
SCALE 1:30		DRAWING NO. EV-14211-L-001	
APPROVED BY J.H.		DRAWING PLAN VIEW	

PLAN VIEW
SCALE 1:30

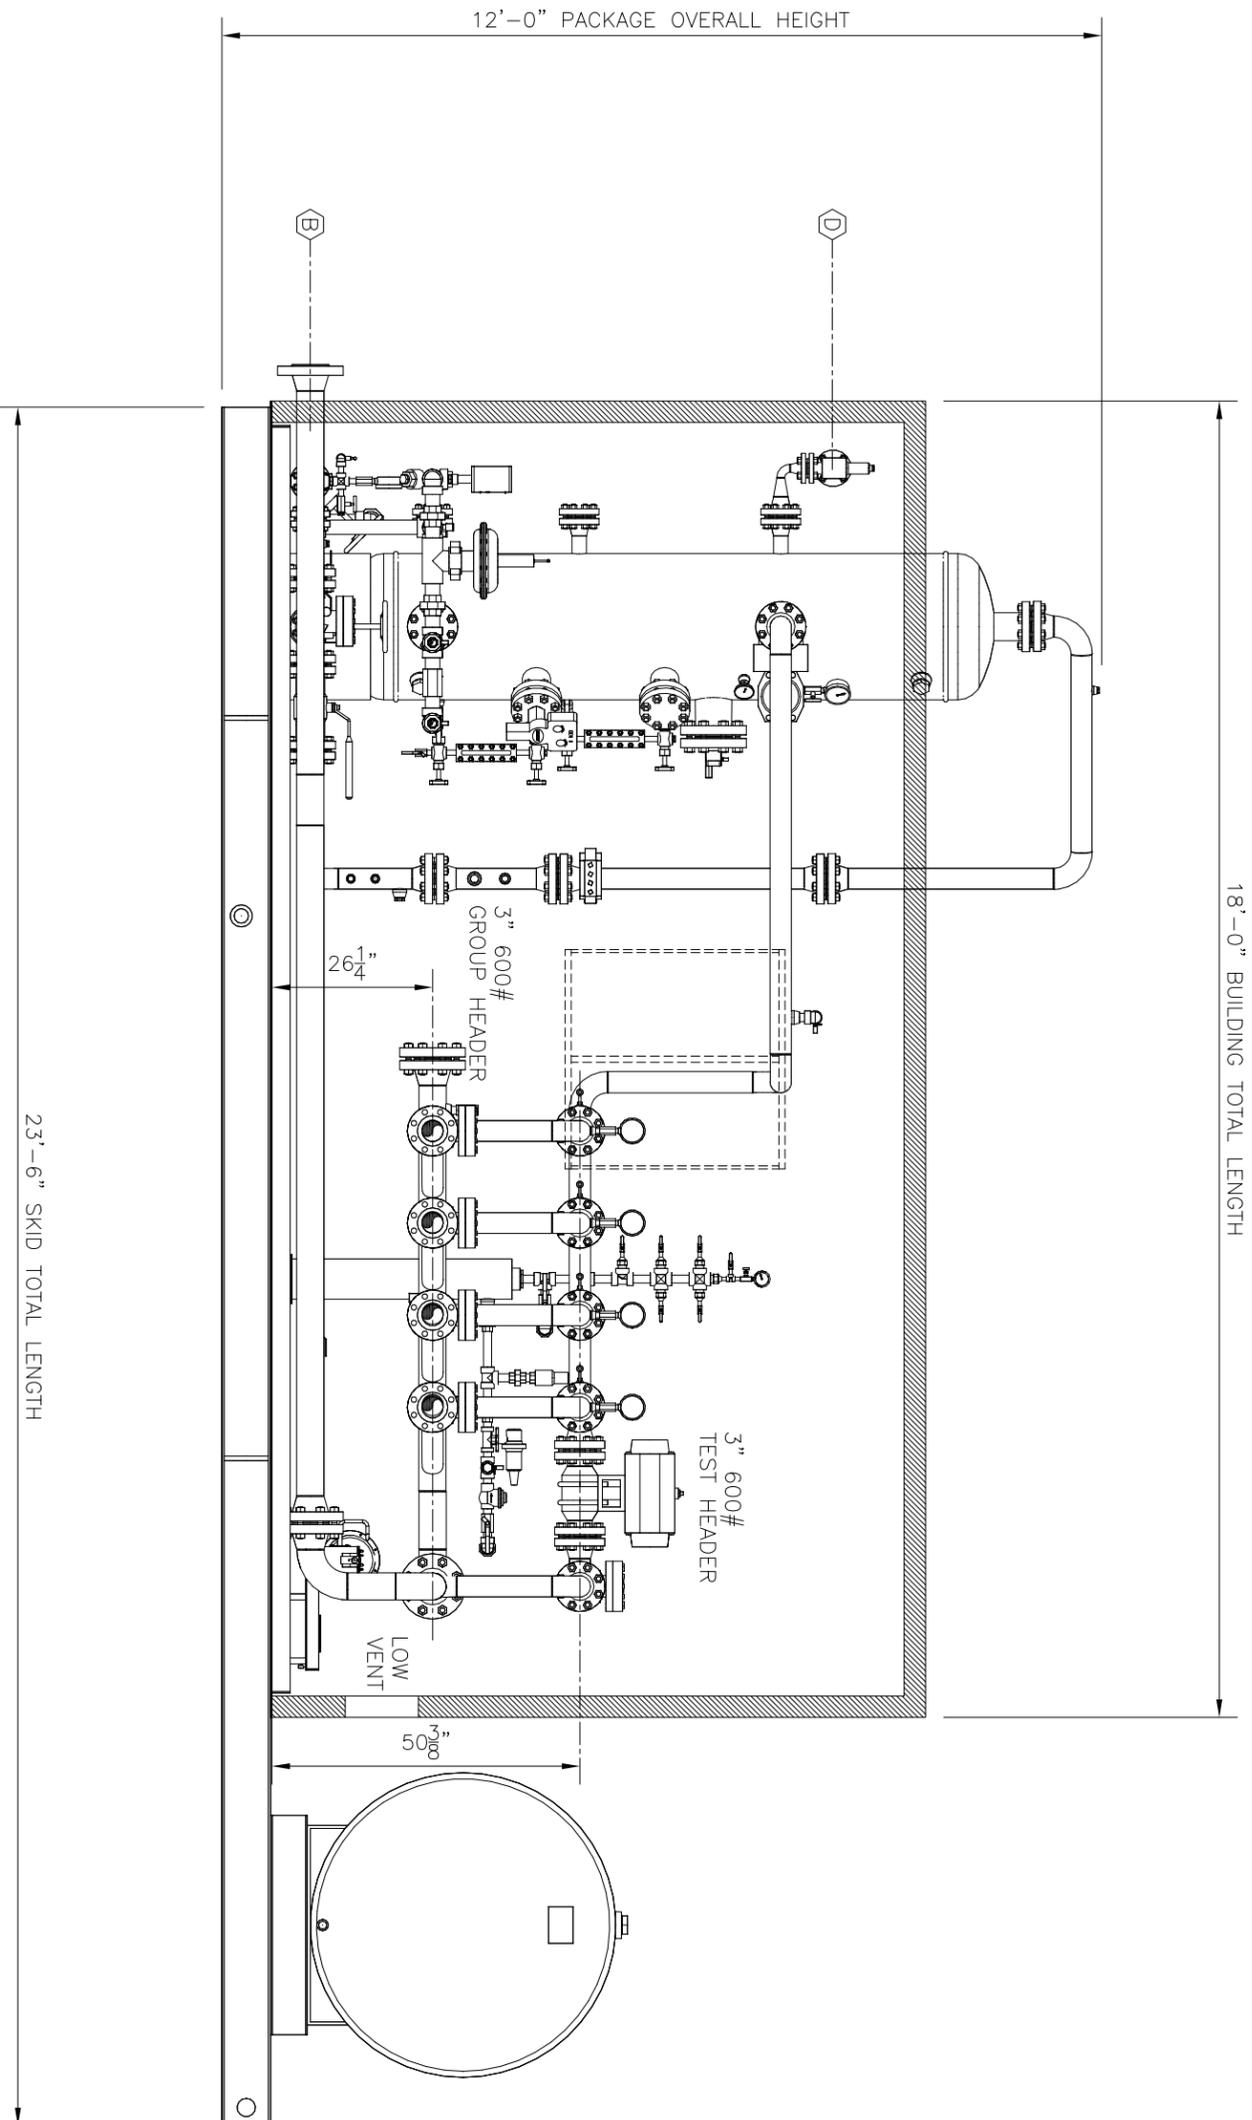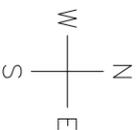

TAG #	SIZE	DESCRIPTION	ELEVATION
A1-4	3" 600# RFWN	INLET	2'-2 1/2" FTOS
B	4" 600# RFWN	GROUP OUTLET	0'-6 1/2" FTOS
C	2" 3000# NPT UNION	V-100 MANUAL DRAIN	1'-4 1/2" FTOS
D	2" 150# RFWN	PSV-100 VENT	7'-7 1/2" FTOS
E	1" 3000# NPT UNION	PROPANE SUPPLY	2'-1 1/2" FTOS
F	1" NPT	PSV-200 VENT	3'-8 1/2" FTOS
G	1" 3000# NPT UNION	WATER PROVER PORT - OUT	2'-2 1/2" FTOS
H	1" 3000# NPT UNION	WATER PROVER PORT - IN	2'-2 1/2" FTOS
J	1" 3000# NPT UNION	FUEL GAS	4'-3" FTOS
K	1" 3000# NPT UNION	INSTRUMENT AIR SUPPLY	3'-8 1/2" FTOS
L	1" 3000# NPT UNION	FUEL GAS SCRUBBER DRAIN	0'-6 1/4" FTOS

NOTES:
 1. ELEVATION MEASUREMENTS ARE FROM TOP OF SKID (FTOS).
 - TO GET A BOTTOM OF SKID MEASUREMENT (FBOS)
 ADD 8 3/8" TO THE ELEVATIONS LISTED
 2. PROJECTION MEASUREMENTS ARE FROM BUILDING EDGE. (FBE)


SHIPPING DIMENSIONS:
 WIDTH: 12'-6"
 LENGTH: 23'-7"
 HEIGHT: 12'-0"
 PACKAGE WEIGHT: 15,500lbs (approximate)

REV	ISSUED FOR CONSTRUCTION	REVISION	BY	APPR	d/m/y
0	ISSUED FOR CONSTRUCTION		BY	APPR	18/09/14





FRONT ELEVATION VIEW
 SCALE 1:30

DATE: 25/11/11	CLIENT: LONGRUN EXPLORATION LTD
DESIGNED BY: M.E.W.	LSD:
DRAWN BY: M.E.W.	TITLE: LAYOUT - ELEVATION VIEW
CHECKED BY:	24'x7'-6" S/S 1440psi - 2 PHASE 4 WELL
APPROVED BY: J.H.	SOUR SERVICE TEST SATELLITE PACKAGE
SCALE: 1:30	JOB #: EV-14211
	SHEET NO: 2 OF 6
	REF. NO.: LAYOUT
	DRAWING NO.: EV-14211-L-002
	DRAWING: ELEVATION VIEW
	REV. NO.: 0

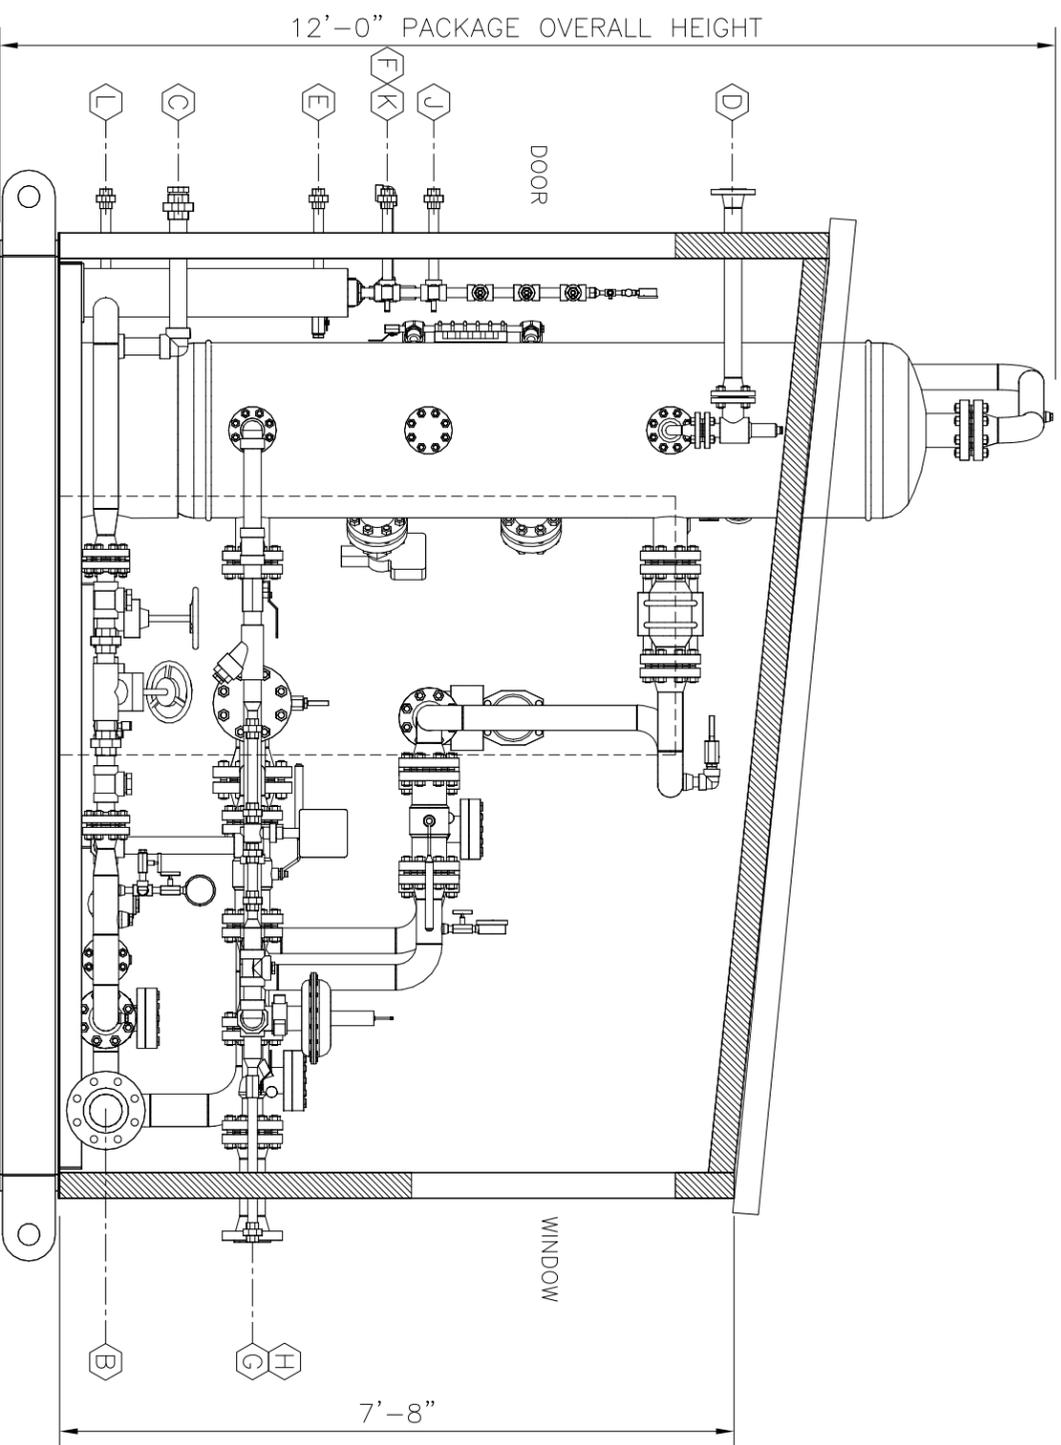

SIDE VIEW
SCALE 1:25

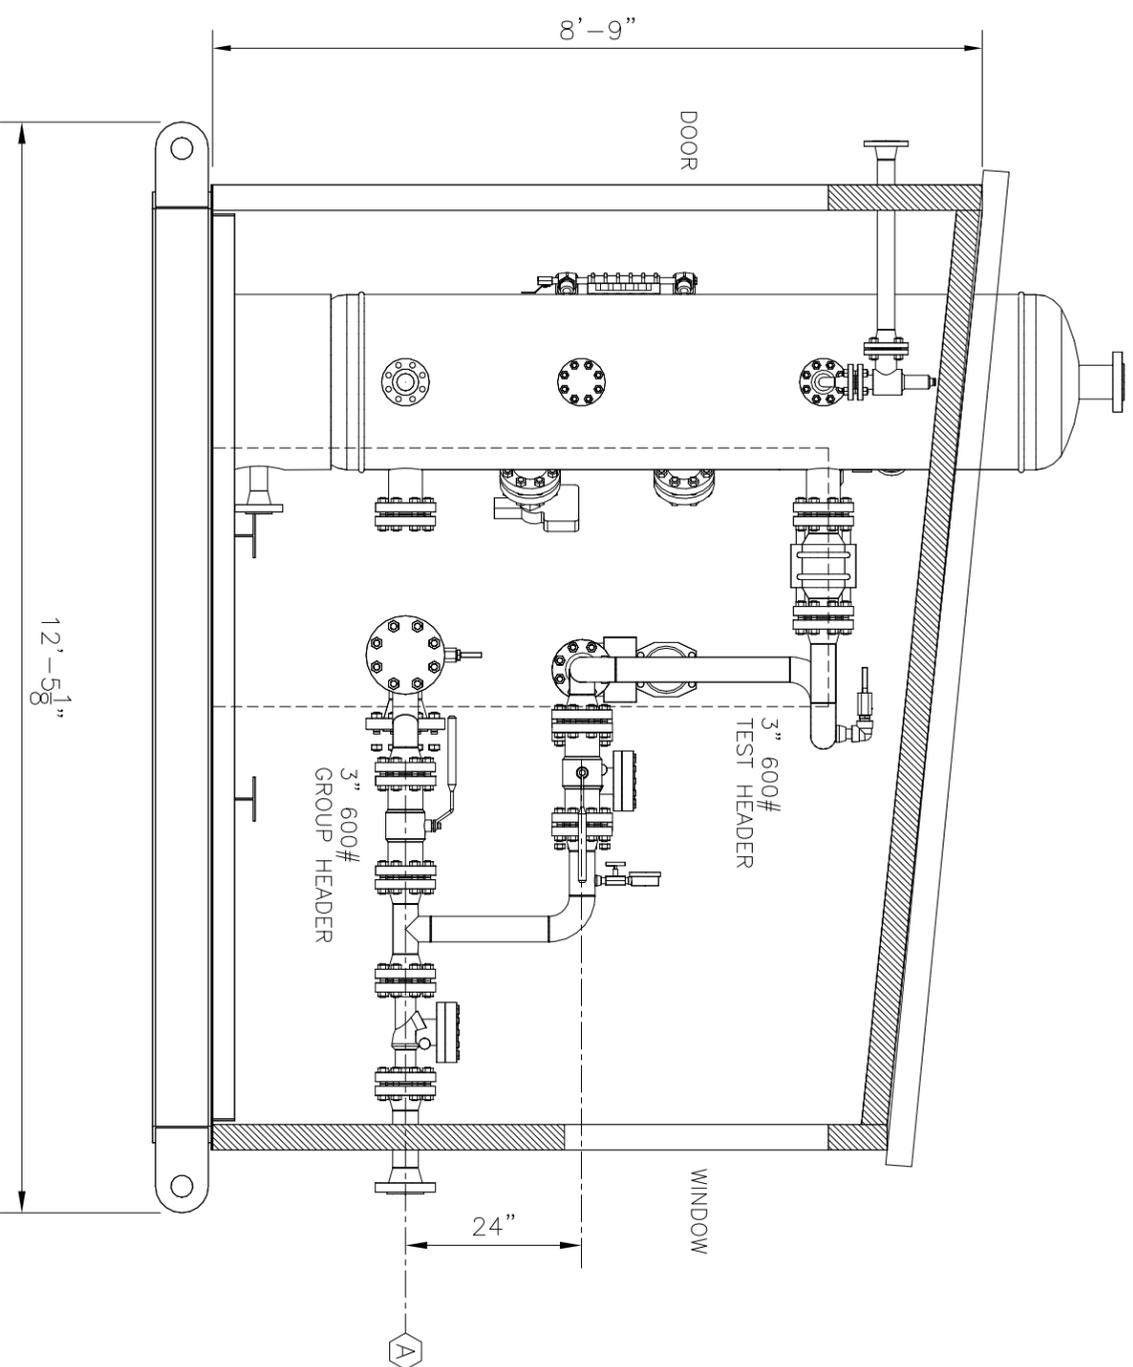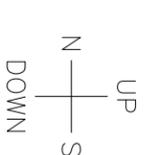

INLET HEADER SIDE VIEW
SCALE 1:25


TAG #	SIZE	DESCRIPTION	ELEVATION
A1-4	3" 600# RFWN	INLET	2'-2 1/4" FTOS
B	4" 600# RFWN	GROUP OUTLET	0'-6 1/2" FTOS
C	2" 3000# NPT UNION	V-100 MANUAL DRAIN	1'-4 1/8" FTOS
D	2" 150# RFWN	PSV-100 VENT	7'-7 1/4" FTOS
E	1" 3000# NPT UNION	PROPANE SUPPLY	2'-1 1/4" FTOS
F	1" NPT	PSV-200 VENT	3'-8 1/2" FTOS
G	1" 3000# NPT UNION	WATER PROVER PORT - OUT	2'-2 1/2" FTOS
H	1" 3000# NPT UNION	WATER PROVER PORT - IN	2'-2 1/4" FTOS
J	1" 3000# NPT UNION	FUEL GAS	4'-3" FTOS
K	1" 3000# NPT UNION	INSTRUMENT AIR SUPPLY	3'-8 3/8" FTOS
L	1" 3000# NPT UNION	FUEL GAS SCRUBBER DRAIN	0'-6 1/4" FTOS

- NOTES:
- ELEVATION MEASUREMENTS ARE FROM TOP OF SKID (FTOS).
- TO GET A BOTTOM OF SKID MEASUREMENT (FBOS)
ADD 8 3/8" TO THE ELEVATIONS LISTED
 - PROJECTION MEASUREMENTS ARE FROM BUILDING EDGE. (FBE)
- SHIPPING DIMENSIONS:
- WIDTH: 12'-6"
LENGTH: 23'-7"
HEIGHT: 12'-0"
PACKAGE WEIGHT: 15,500lbs (approximate)

REV	ISSUED FOR CONSTRUCTION	REVISION	BY	APPR	d/m/y
0	ISSUED FOR CONSTRUCTION		EVC		18/09/14

info@evolutionequipment.com
www.evolutionequipment.com

DATE	25/11/11	CLIENT	LONGRUN EXPLORATION LTD
DESIGNED BY	M.E.W.	LSD:	
DRAWN BY	M.E.W.	TITLE	LAYOUT - END VIEWS
CHECKED BY			24"x7'-6" S/S 1440psi - 2 PHASE 4 WELL
APPROVED BY	J.H.		SOUR SERVICE TEST SATELLITE PACKAGE
SCALE	1:25	JOB #	EV-14211
		SHEET NO.	3 OF 6
		DRAWING NO.	EV-14211-L-003
		REV. NO.	0

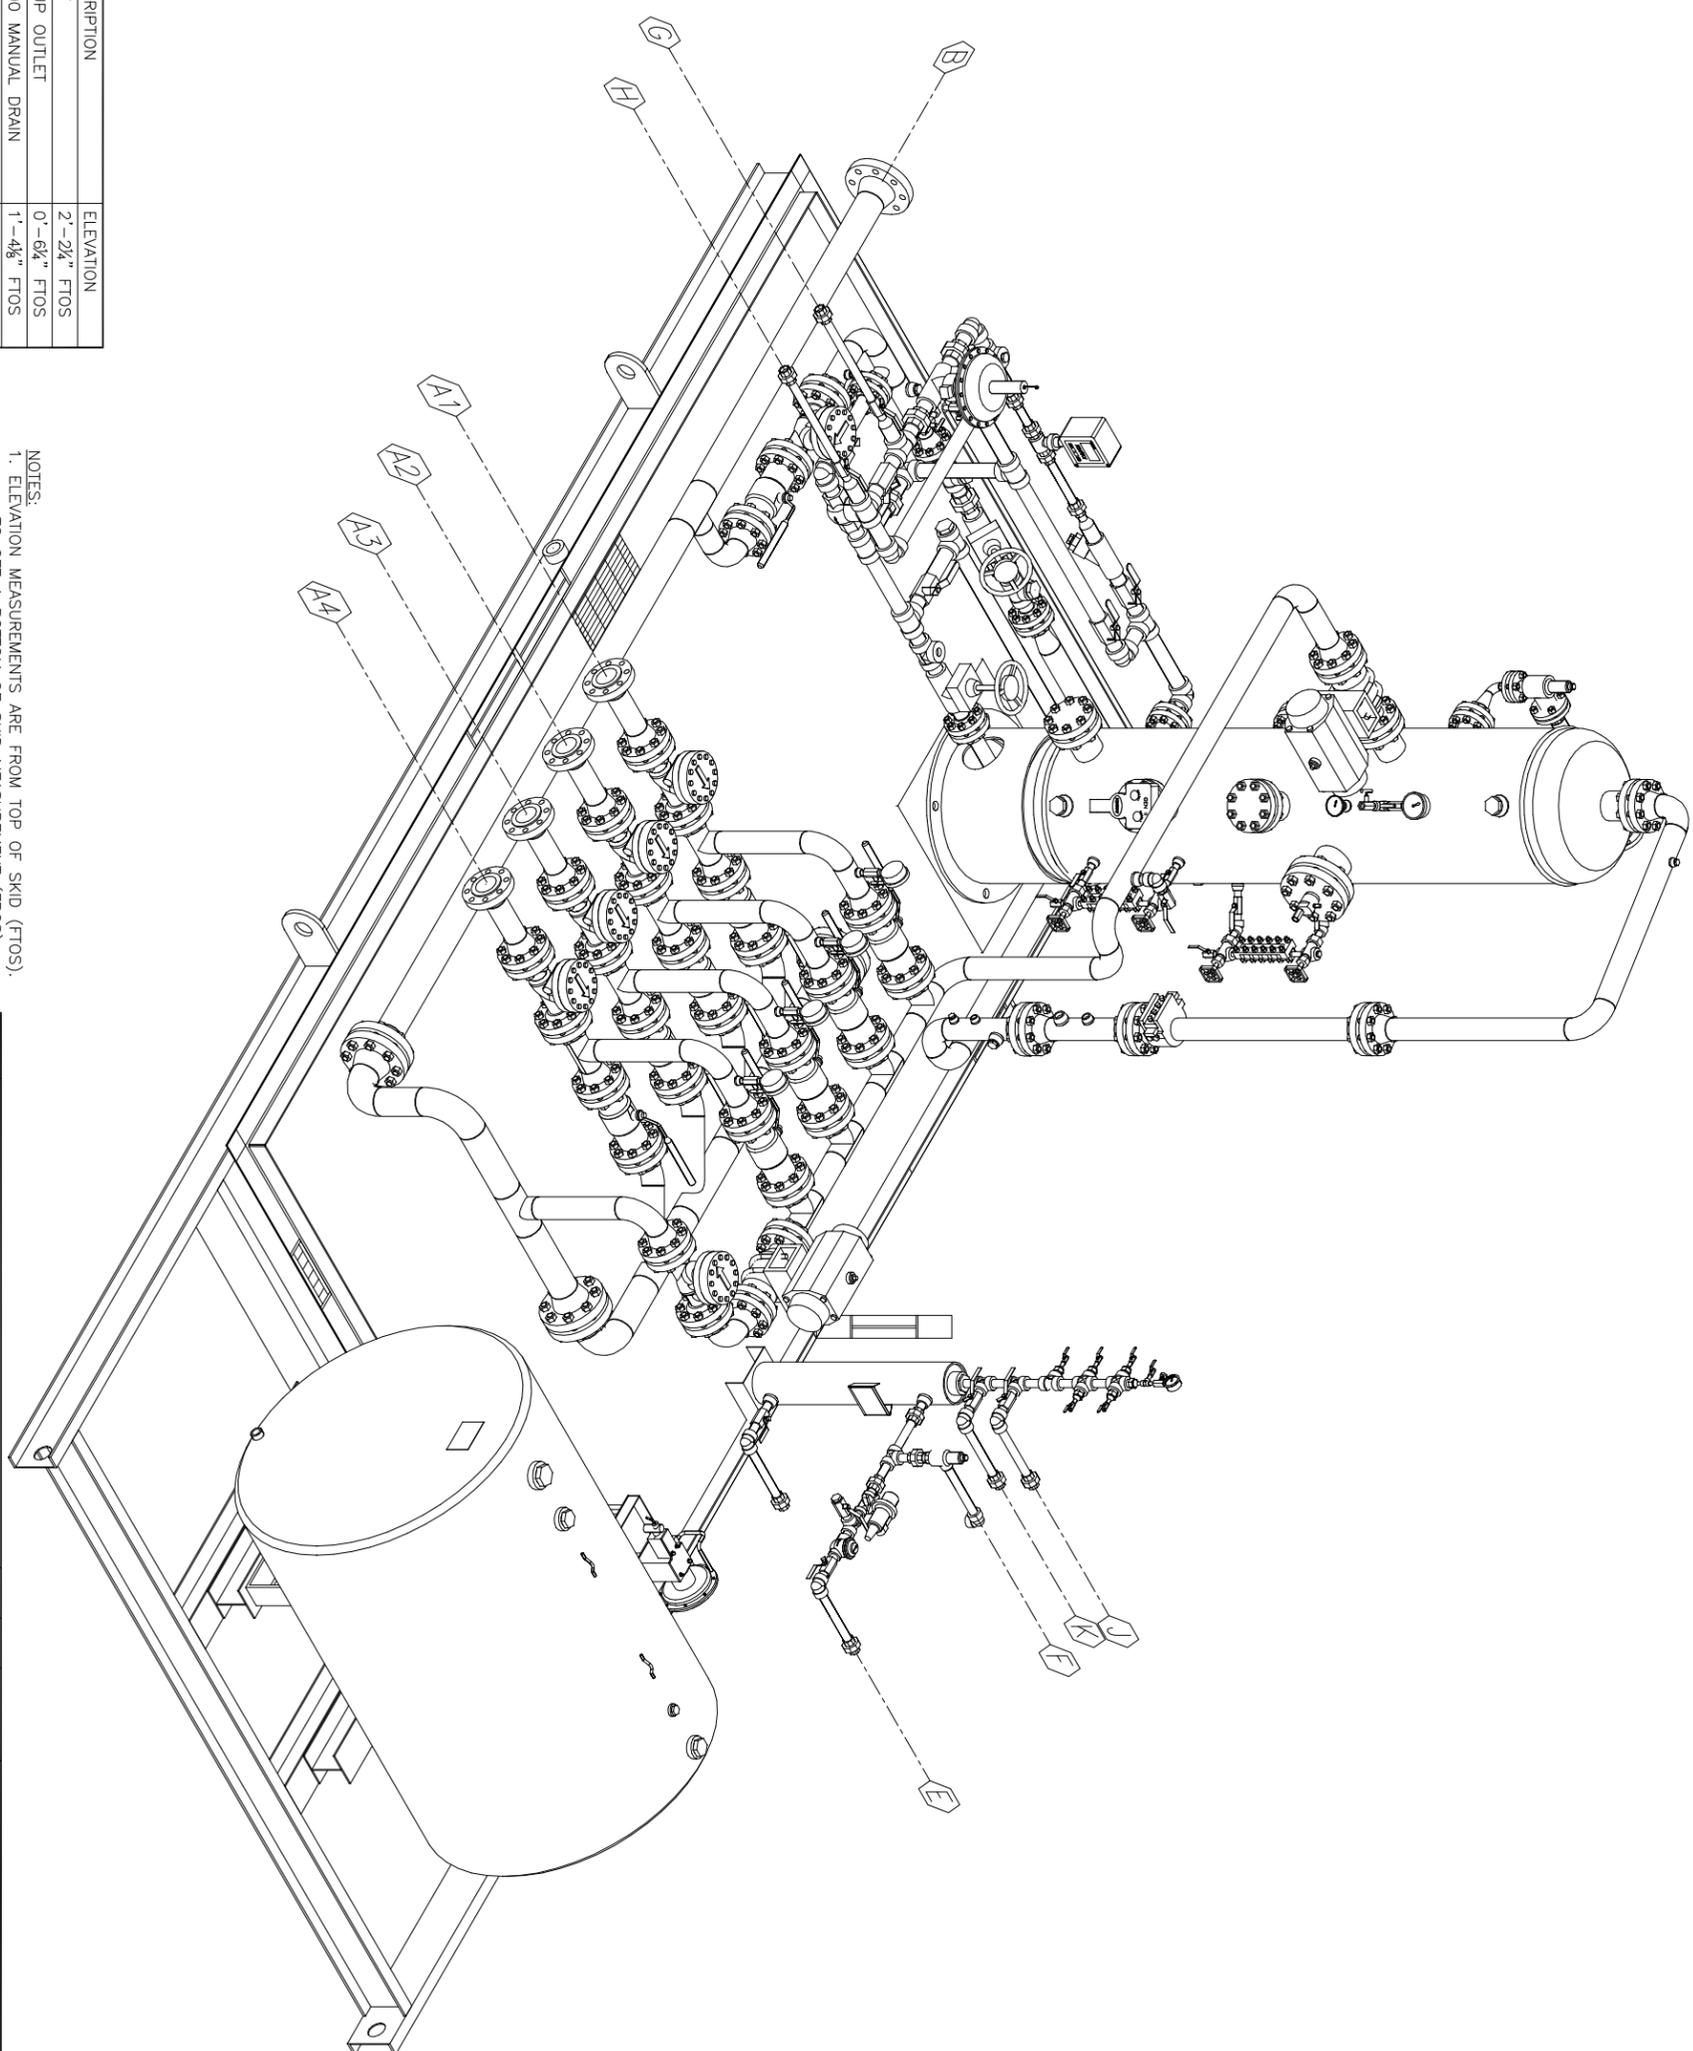

TAG #	SIZE	DESCRIPTION	ELEVATION
A1-4	3" 600# RFWN	INLET	2'-2 1/4" FTOS
B	4" 600# RFWN	GROUP OUTLET	0'-6 1/2" FTOS
C	2" 3000# NPT UNION	V-100 MANUAL DRAIN	1'-4 1/2" FTOS
D	2" 150# RFWN	PSV-100 VENT	7'-7 1/4" FTOS
E	1" 3000# NPT UNION	PROPANE SUPPLY	2'-1 1/2" FTOS
F	1" NPT	PSV-200 VENT	3'-8 1/2" FTOS
G	1" 3000# NPT UNION	WATER PROVER PORT - OUT	2'-2 1/2" FTOS
H	1" 3000# NPT UNION	WATER PROVER PORT - IN	2'-2 1/4" FTOS
J	1" 3000# NPT UNION	FUEL GAS	4'-3" FTOS
K	1" 3000# NPT UNION	INSTRUMENT AIR SUPPLY	3'-8 3/8" FTOS
L	1" 3000# NPT UNION	FUEL GAS SCRUBBER DRAIN	0'-6 1/4" FTOS

NOTES:
 1. ELEVATION MEASUREMENTS ARE FROM TOP OF SKID (FTOS).
 - TO GET A BOTTOM OF SKID MEASUREMENT (FBOS)
 ADD 8 3/8" TO THE ELEVATIONS LISTED
 2. PROJECTION MEASUREMENTS ARE FROM BUILDING EDGE. (FBE)

SHIPPING DIMENSIONS:
 WIDTH: 12'-6"
 LENGTH: 23'-7"
 HEIGHT: 12'-0"
 PACKAGE WEIGHT: 15,500lbs (approximate)


REV	ISSUED FOR CONSTRUCTION	REVISION	BY	APPR	d/m/y
0	ISSUED FOR CONSTRUCTION		EVC		18/09/14



'SE' ISOMETRIC VIEW
 SCALE 1:30

DATE	DESIGNED BY	DRAWN BY	CHECKED BY	APPROVED BY	SCALE
25/11/11	M.E.W.	M.E.W.		J.H.	1:30

CLIENT	TITLE	JOB #	REF. NO.	DRAWING NO.	SCALE
LONGRUN EXPLORATION LTD	LAYOUT - 'SE' ISOMETRIC VIEW	EV-14211		EV-14211-L-004	1:30

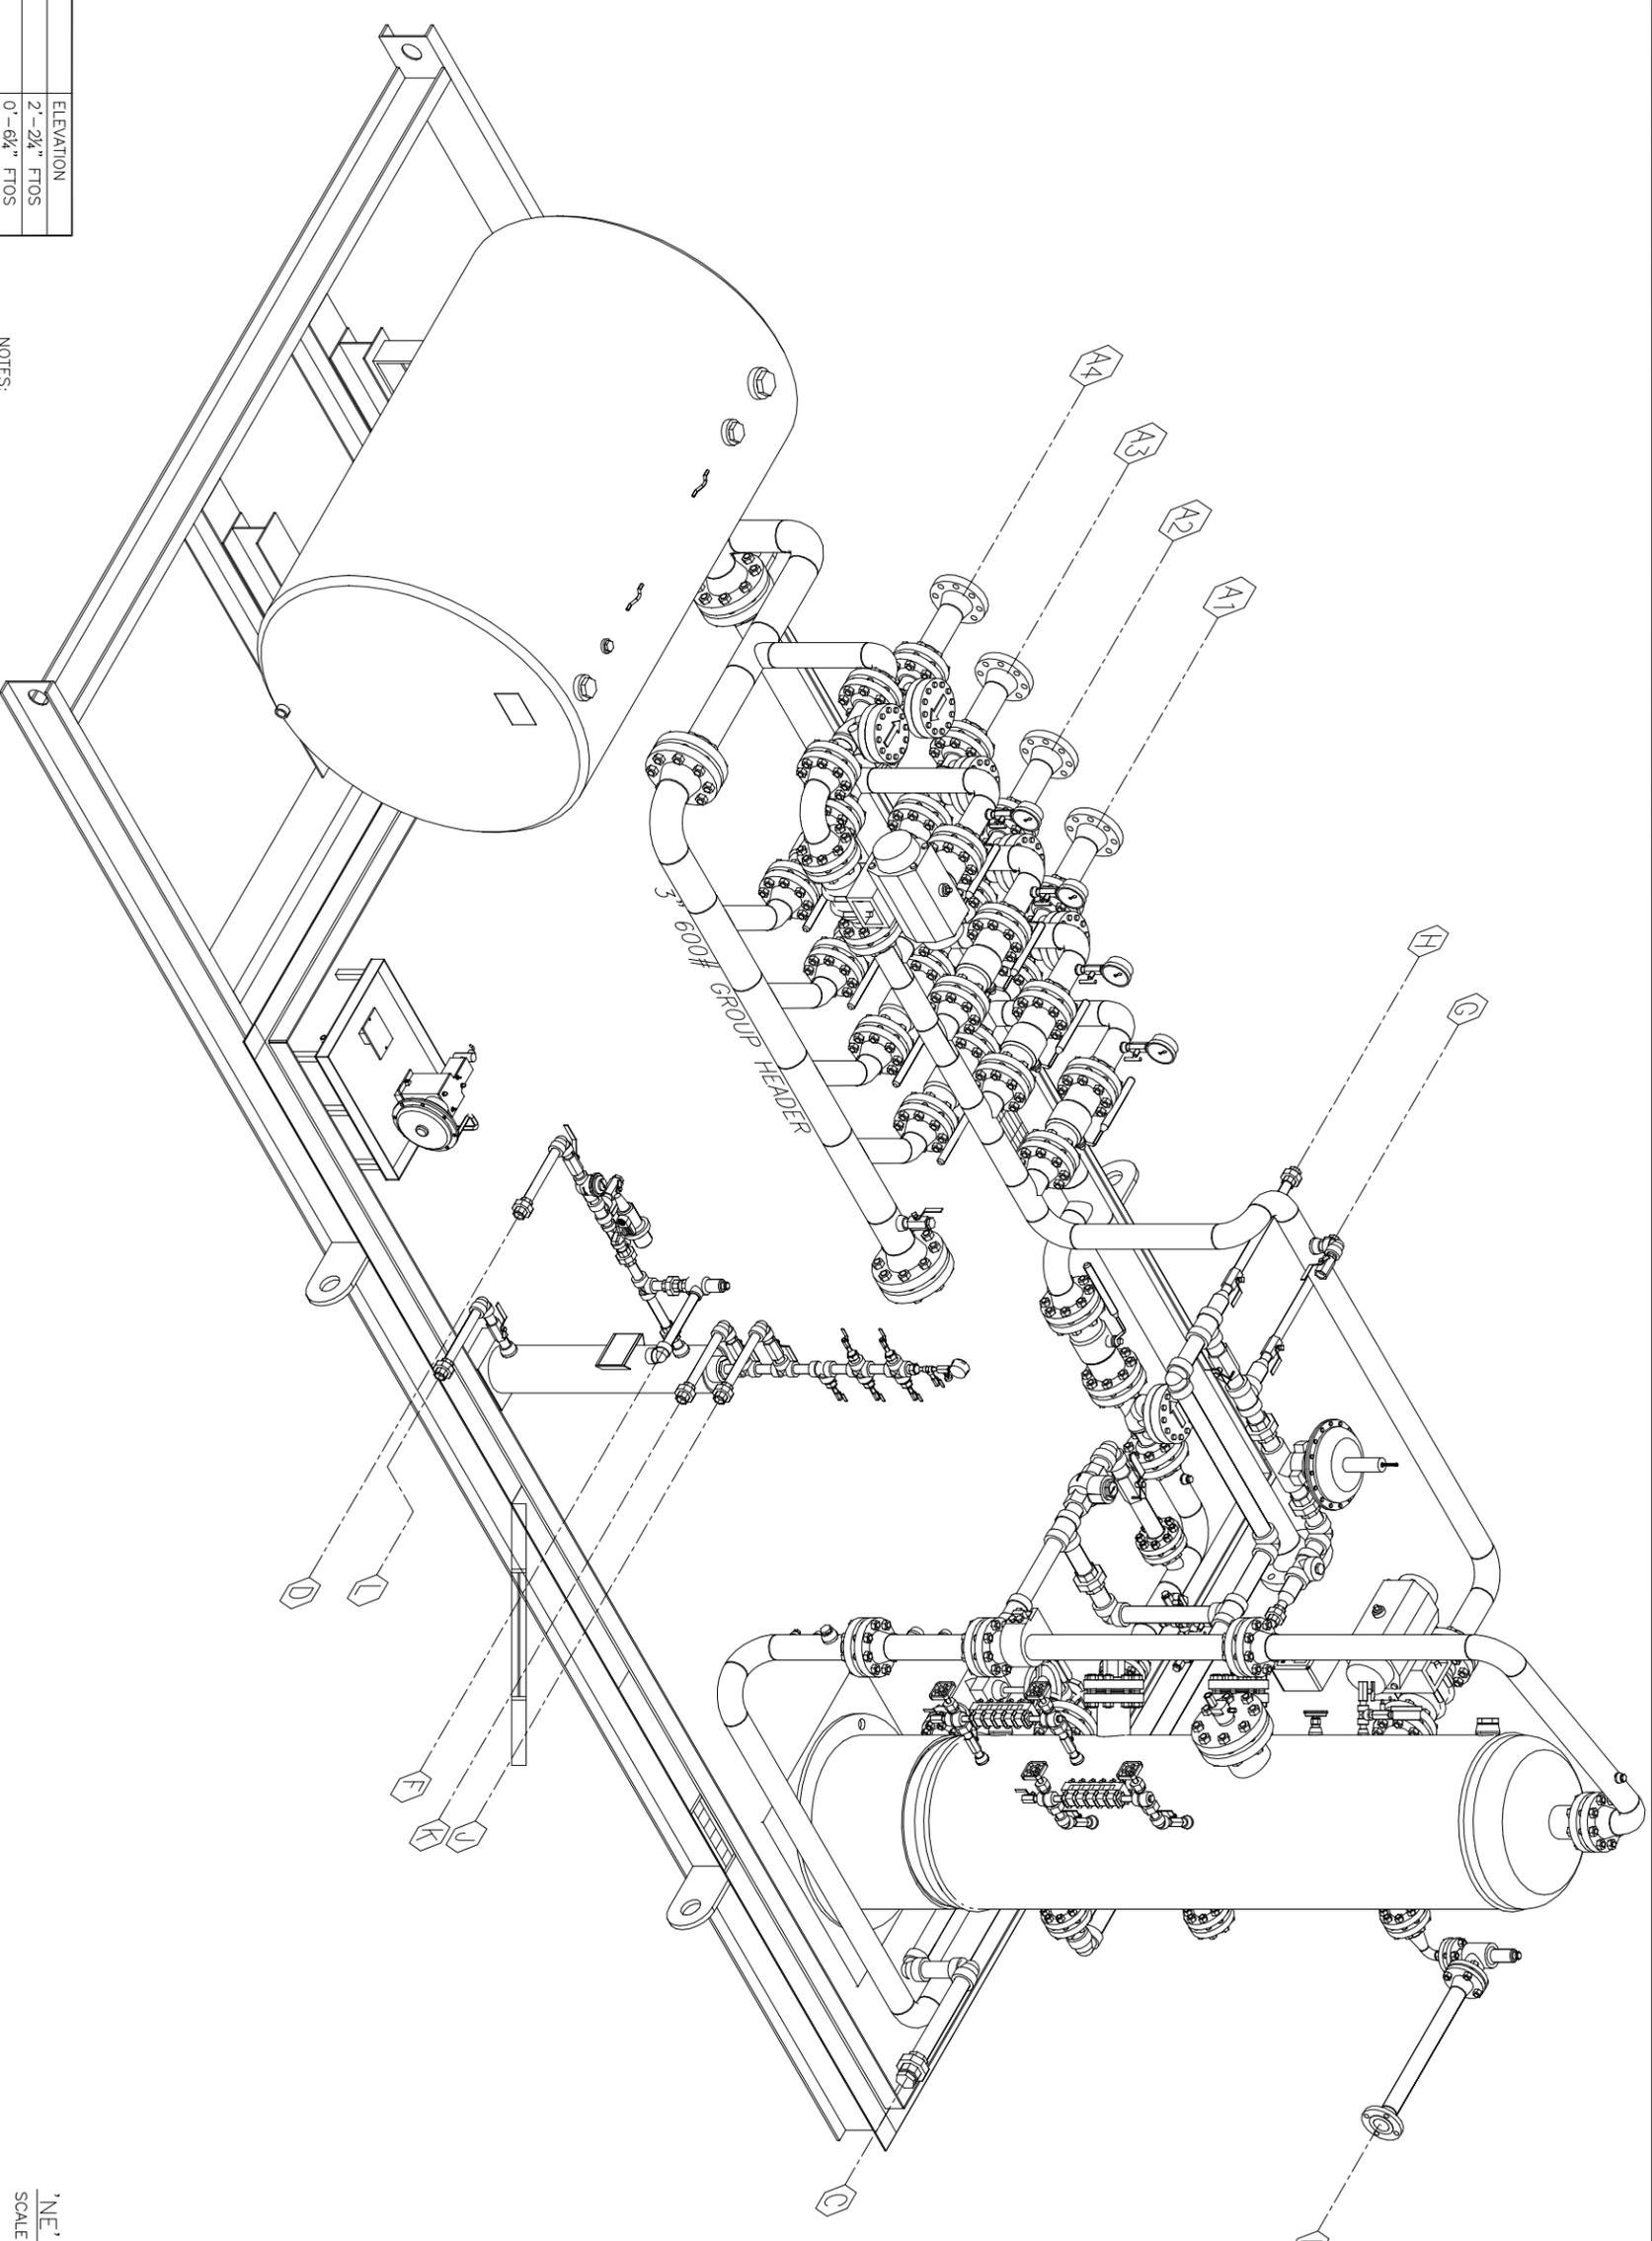

TAG #	SIZE	DESCRIPTION	ELEVATION
A1-4	3" 600# RFWN	INLET	2'-2 1/2" FTOS
B	4" 600# RFWN	GROUP OUTLET	0'-6 1/2" FTOS
C	2" 3000# NPT UNION	V-100 MANUAL DRAIN	1'-4 1/2" FTOS
D	2" 150# RFWN	PSV-100 VENT	7'-7 1/2" FTOS
E	1" 3000# NPT UNION	PROPANE SUPPLY	2'-1 1/2" FTOS
F	1" NPT	PSV-200 VENT	3'-8 1/2" FTOS
G	1" 3000# NPT UNION	WATER PROVER PORT - OUT	2'-2 1/2" FTOS
H	1" 3000# NPT UNION	WATER PROVER PORT - IN	2'-2 1/2" FTOS
J	1" 3000# NPT UNION	FUEL GAS	4'-3" FTOS
K	1" 3000# NPT UNION	INSTRUMENT AIR SUPPLY	3'-8 1/2" FTOS
L	1" 3000# NPT UNION	FUEL GAS SCRUBBER DRAIN	0'-6 1/2" FTOS

- NOTES:
- ELEVATION MEASUREMENTS ARE FROM TOP OF SKID (FTOS).
- TO GET A BOTTOM OF SKID MEASUREMENT (FBOS)
ADD 8 3/8" TO THE ELEVATIONS LISTED
 - PROJECTION MEASUREMENTS ARE FROM BUILDING EDGE. (FBE)

SHIPPING DIMENSIONS:
 WIDTH: 12'-6"
 LENGTH: 23'-7"
 HEIGHT: 12'-0"
 PACKAGE WEIGHT: 15,500lbs (approximate)


REV	ISSUED FOR CONSTRUCTION	REVISION	BY	APPR	d/m/y
0	ISSUED FOR CONSTRUCTION		EVC		18/09/14

Evolution
PRODUCTION EQUIPMENT

info@evolutionequipment.com
www.evolutionequipment.com

DATE	25/11/11	CLIENT	LONGRUN EXPLORATION LTD
DESIGNED BY	M.E.W.	LSD:	
DRAWN BY	M.E.W.	TITLE	LAYOUT - 'NE' ISOMETRIC VIEW
CHECKED BY			24"x7'-6" S/S 1440psi - 2 PHASE 4 WELL
APPROVED BY	J.H.	JOB #	EV-14211
SCALE	1:30	SHEET NO	5 OF 6
		DRAWING NO.	EV-14211-L-005
		DRAWING	NE ISO VIEW
		REV. NO.	0

'NE' ISOMETRIC VIEW
SCALE 1:30

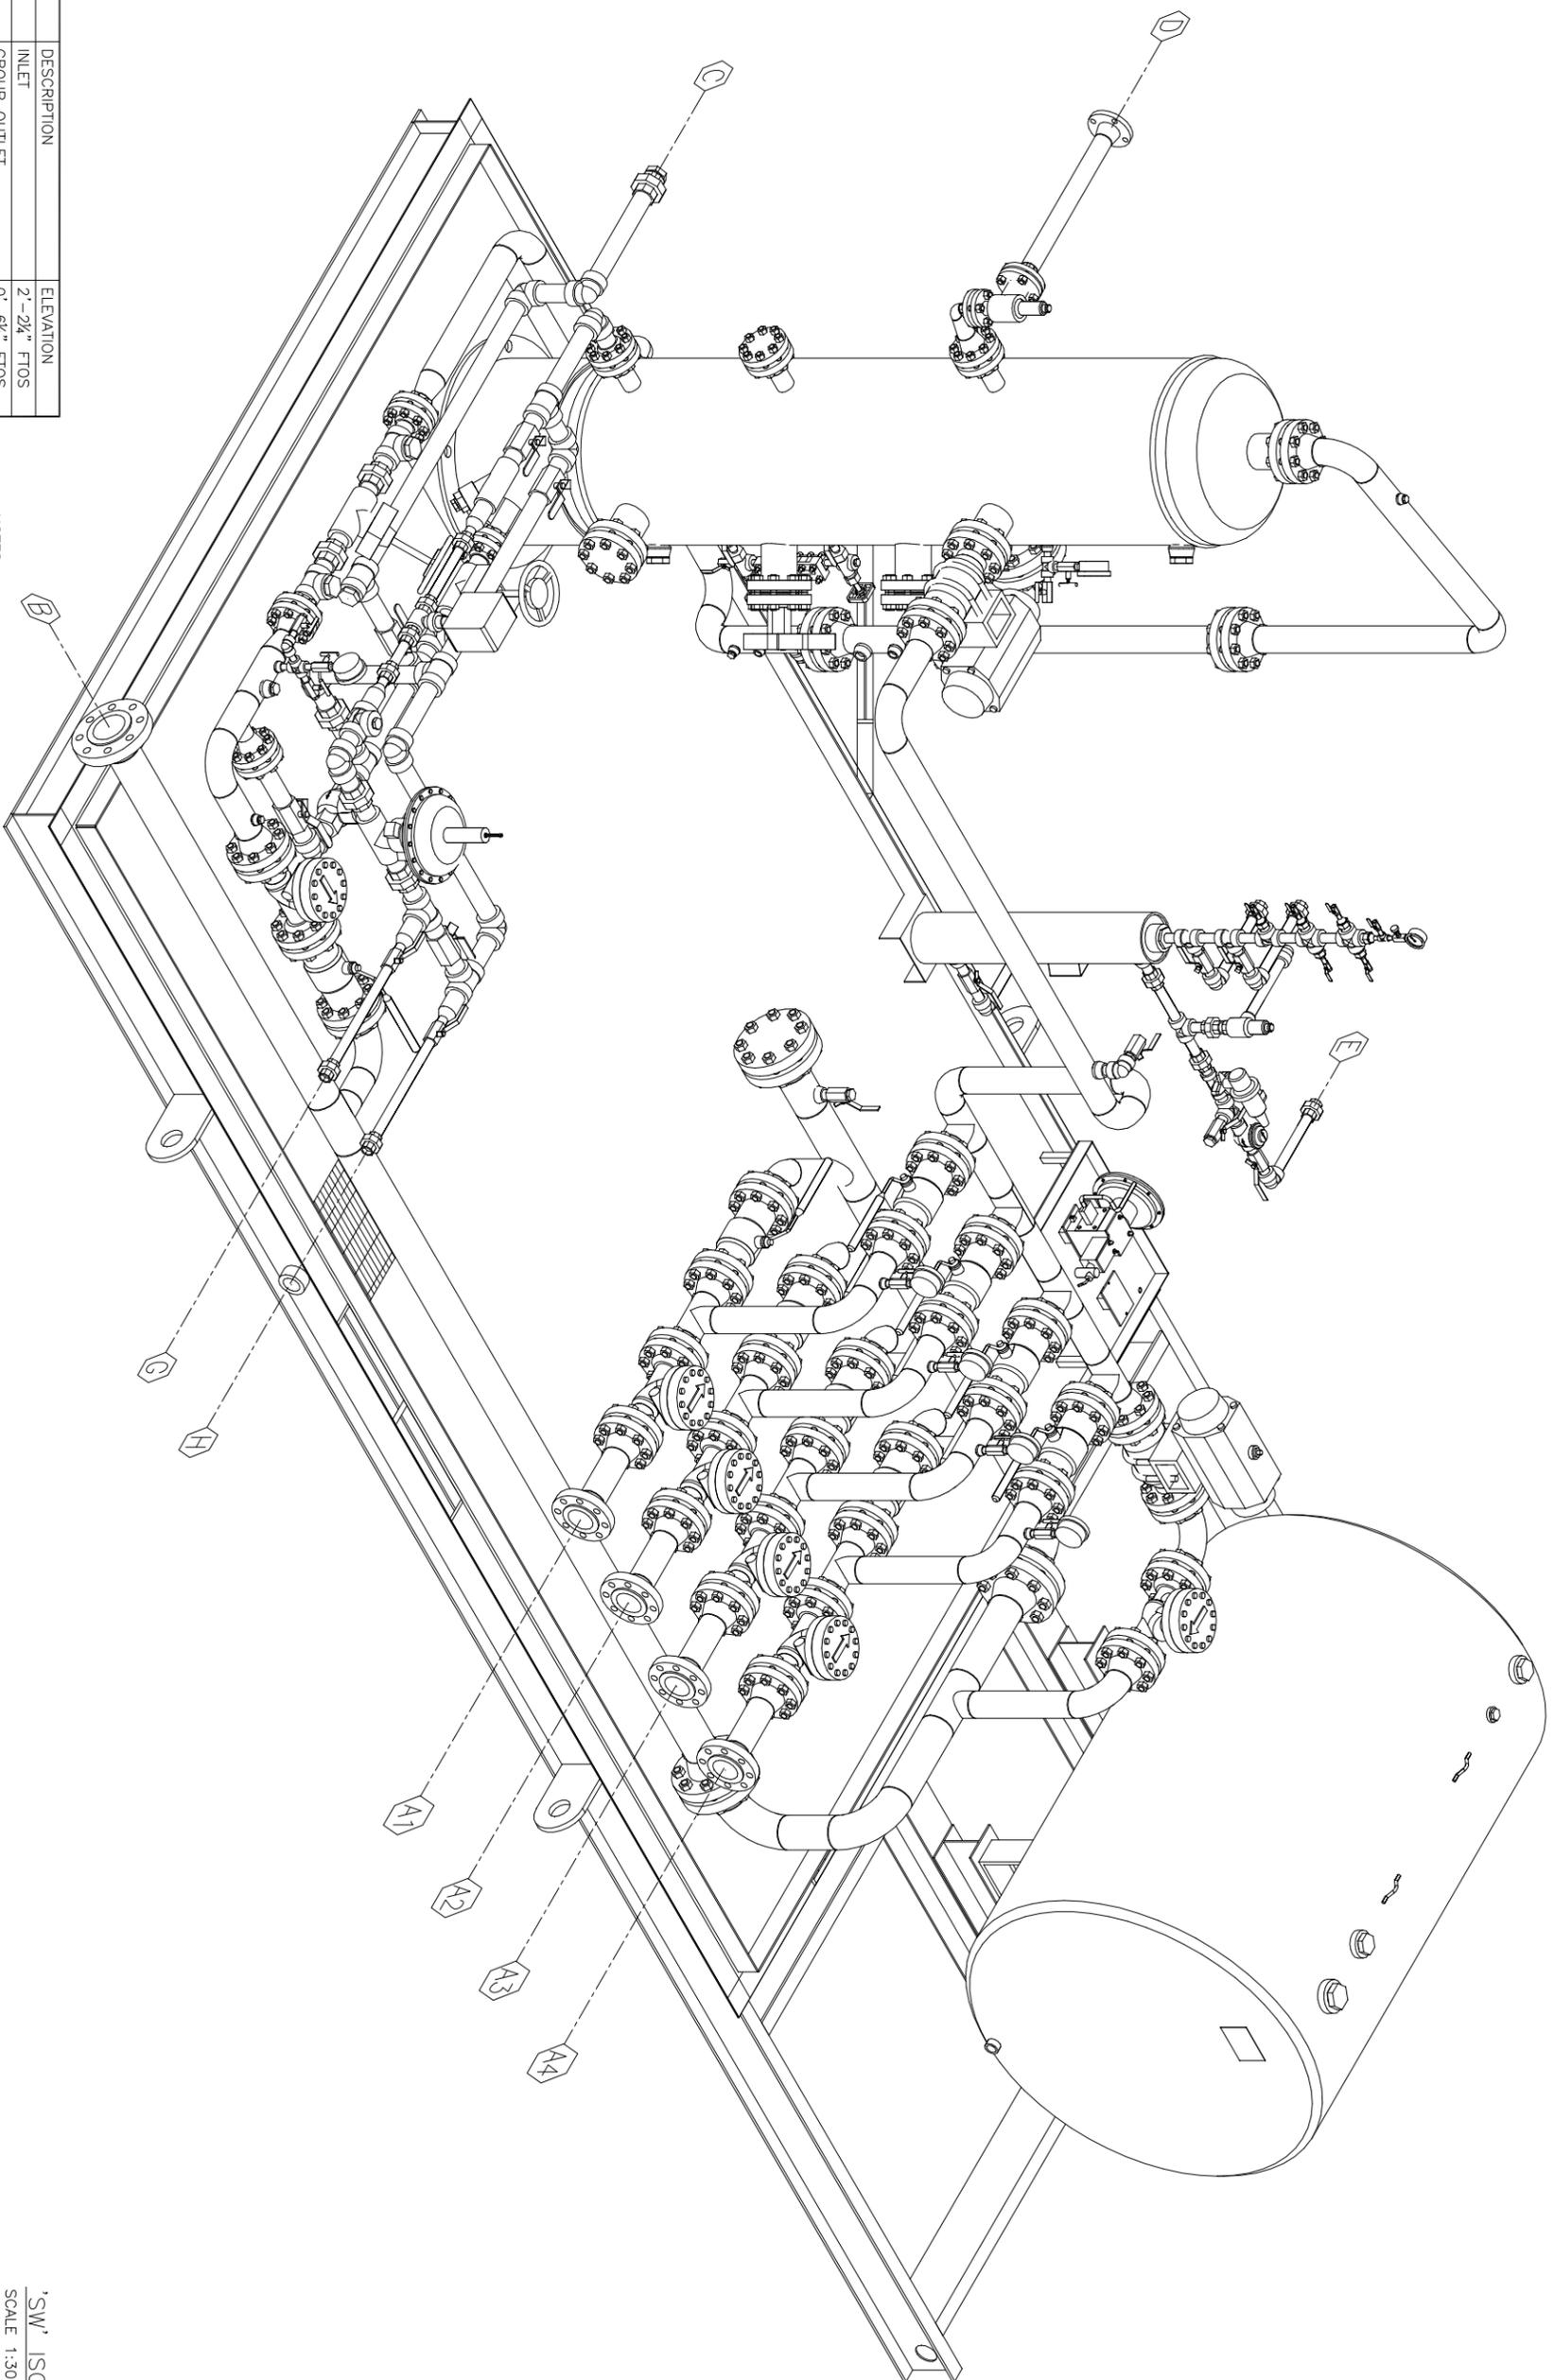

TAG #	SIZE	DESCRIPTION	ELEVATION
A1-4	3" 600# RFWN	INLET	2'-2 1/2" FTOS
B	4" 600# RFWN	GROUP OUTLET	0'-6 1/2" FTOS
C	2" 3000# NPT UNION	V-100 MANUAL DRAIN	1'-4 1/2" FTOS
D	2" 150# RFWN	PSV-100 VENT	7'-7 1/2" FTOS
E	1" 3000# NPT UNION	PROPANE SUPPLY	2'-1 1/2" FTOS
F	1" NPT	PSV-200 VENT	3'-8 1/2" FTOS
G	1" 3000# NPT UNION	WATER PROVER PORT - OUT	2'-2 1/2" FTOS
H	1" 3000# NPT UNION	WATER PROVER PORT - IN	2'-2 1/2" FTOS
J	1" 3000# NPT UNION	FUEL GAS	4'-3" FTOS
K	1" 3000# NPT UNION	INSTRUMENT AIR SUPPLY	3'-8 1/2" FTOS
L	1" 3000# NPT UNION	FUEL GAS SCRUBBER DRAIN	0'-6 1/2" FTOS

- NOTES:
- ELEVATION MEASUREMENTS ARE FROM TOP OF SKID (FTOS).
- TO GET A BOTTOM OF SKID MEASUREMENT (FBOS)
ADD 8 3/8" TO THE ELEVATIONS LISTED
 - PROJECTION MEASUREMENTS ARE FROM BUILDING EDGE. (FBE)

SHIPPING DIMENSIONS:
WIDTH: 12'-6"
LENGTH: 23'-7"
HEIGHT: 12'-0"
PACKAGE WEIGHT: 15,500lbs (approximate)

REV	ISSUED FOR CONSTRUCTION	REVISION	BY	APPR	d/m/y
0	ISSUED FOR CONSTRUCTION		EVC		18/09/14



'SW' ISOMETRIC VIEW
SCALE 1:30

DATE	DESIGNED BY	DRAWN BY	CHECKED BY	APPROVED BY	JOB #	SHEET NO	OF	CLIENT	TITLE	REF. NO.	DRAWING NO.	SCALE
25/11/11	M.E.W.	M.E.W.		J.H.	EV-14211	6	6	LONGRUN EXPLORATION LTD	LAYOUT - 'SW' ISOMETRIC VIEW		EV-14211-L-006	1:30