


THIS DRAWING IS THE PROPERTY OF ASPIRE ENERGY RESOURCES LTD. IT MAY NOT BE REPRODUCED WITHOUT THE PERMISSION OF ASPIRE ENERGY RESOURCES LTD.

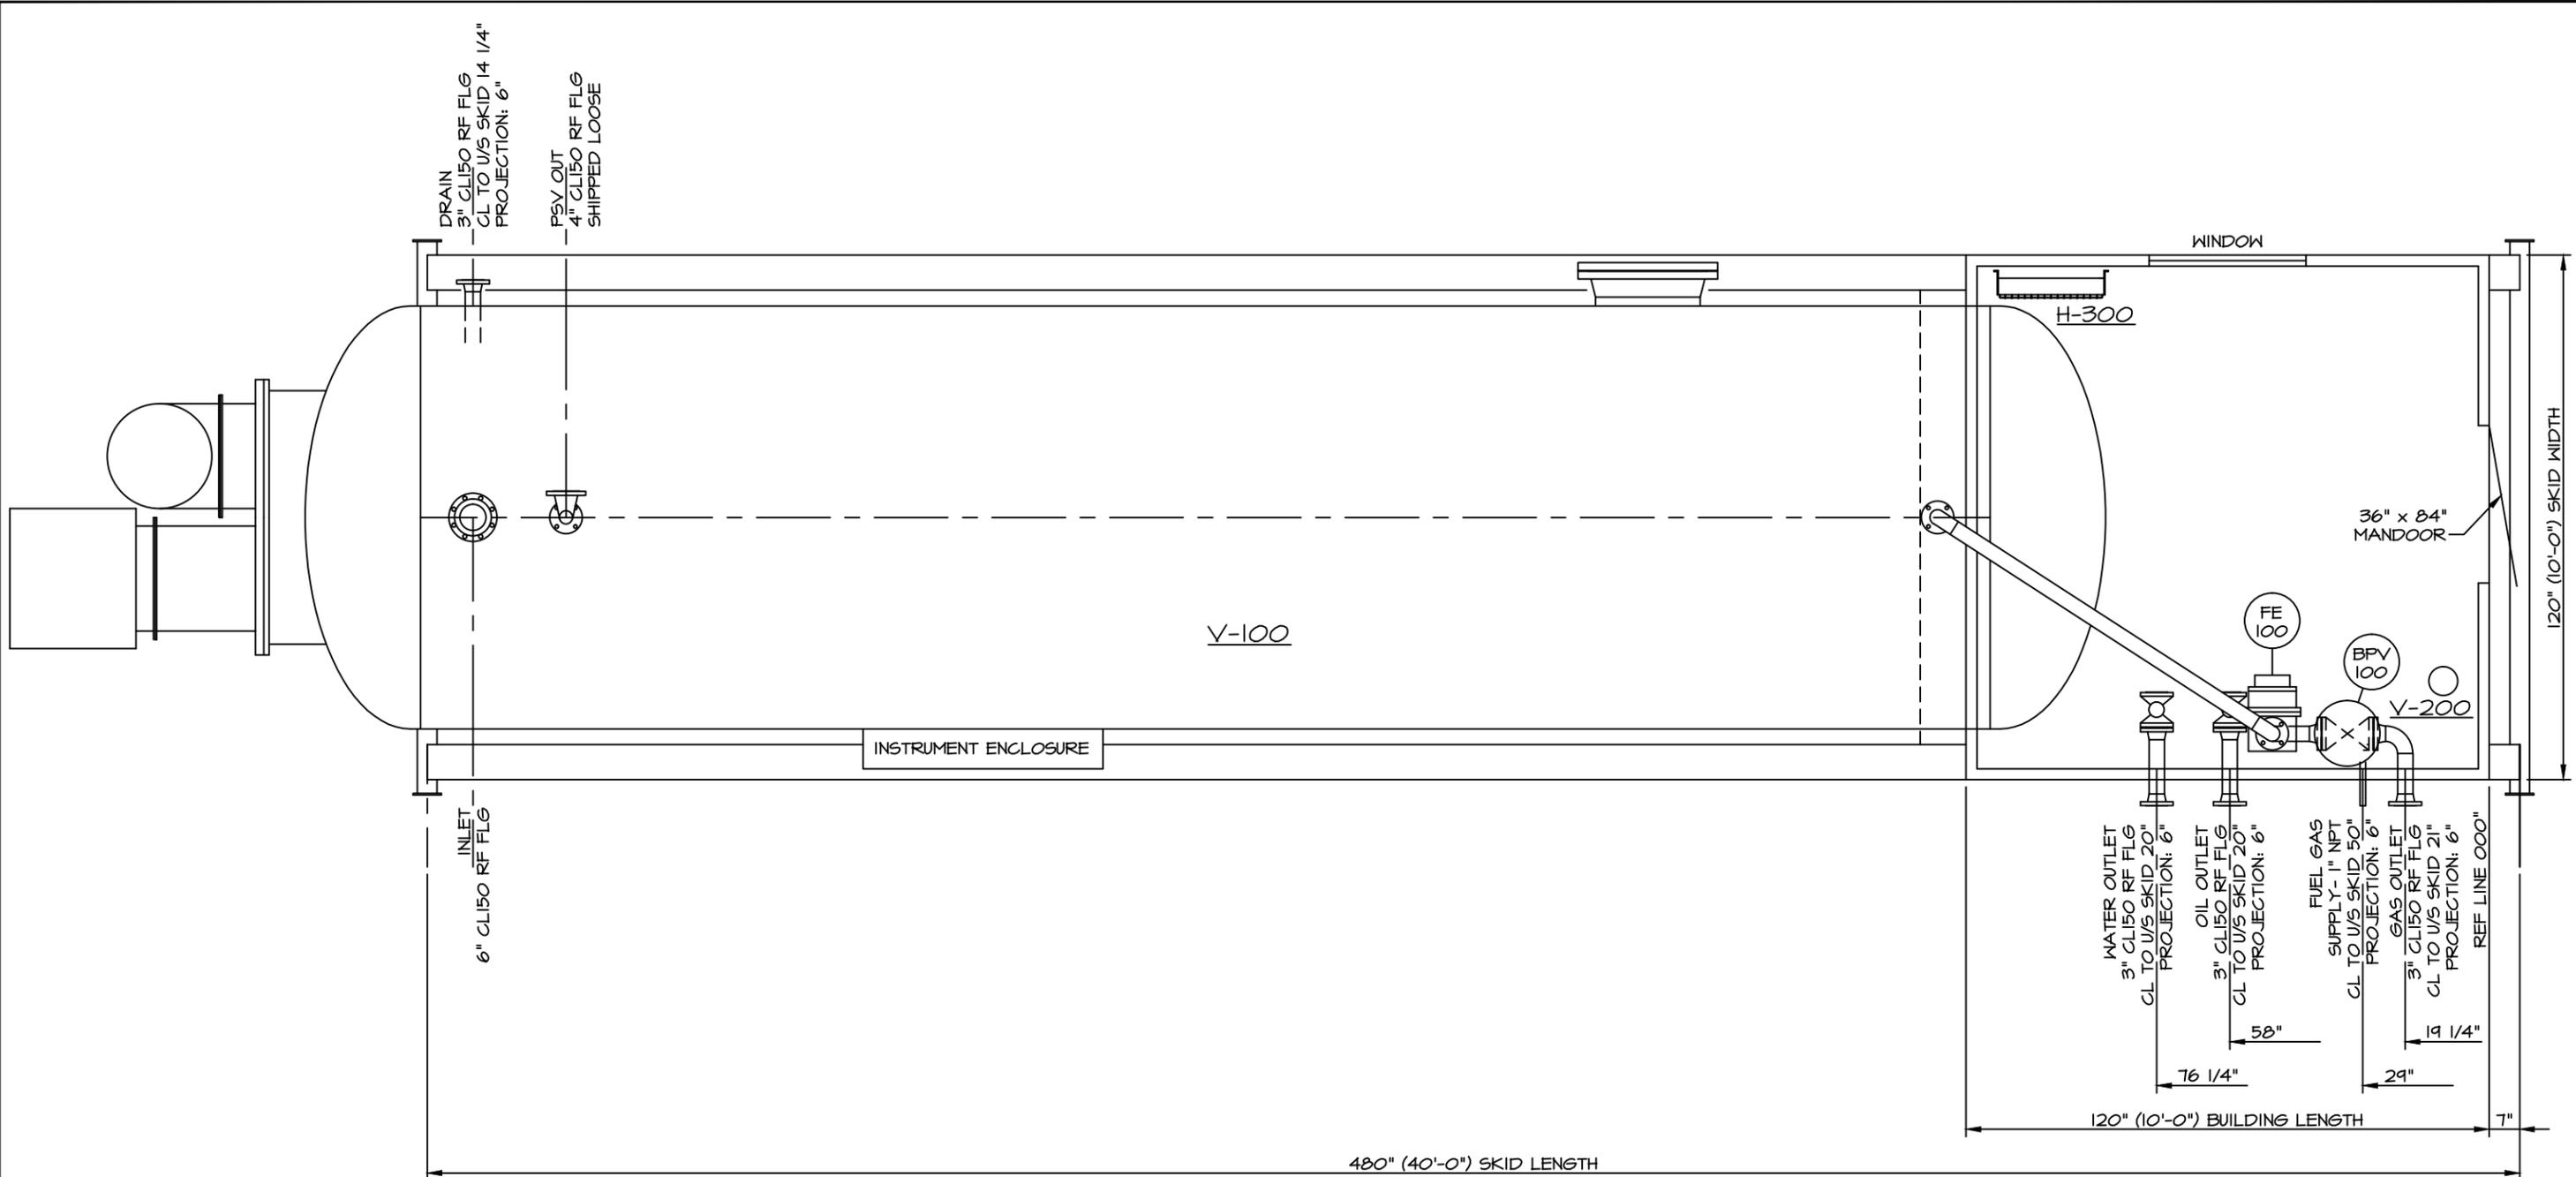

SKID PLAN VIEW

JOB NO. 4092

GENERAL NOTES:

1. UNDERSIDE OF SKID: ELEVATION 000"
2. REFERENCE DRAWINGS: 3151-01 P&ID
3151-03 SKID

NO.	DATE	REVISION	BY	APP
I	12-02-14	AS BUILT	PJD...	WS
O	12-01-25	ISSUED FOR APPROVAL	PJD...	WS

ASPIRE ENERGY RESOURCES LTD.
 4304, 39139 HIGHWAY 2A
 RED DEER, AB T4S 2A8
 TELEPHONE: (403) 314-5422 FAX: (403) 314-1823

CLIENT:	96" TREATER PACKAGE		
DATE: 12-01-25	PIPING PLAN VIEW		
BDD NO.: 3151	10'-0" WIDE x 40'-0" LG		
CUST. NO.: 4092	DWG NO.:	REV.:	
SCALE: NTS	3751-02	1	
DRAWN BY: PJD...			
CHECKED BY: WS			
APP BY:			